

Charles R. Francis
AIA

Diane H. Filipowicz
Assoc. AIA

January 25, 2012

Addendum # G-1

Project: Adaptive Reuse: Craven County Jail to Emergency Operations Center
Phase 1 - Demolition

Owner: Craven County
Address: Craven Street
City: New Bern, NC

DRAWINGS:

- [1] Sheet a1.1 Level 2 – Demolition [plan]
Omit demolition of existing toilet.
- [2] Sheet a1.1 Level 2 – Demolition [plan]
Add the demolition of a portion of a CMU wall for the future installation of a new door and frame. Demolition includes the installation of a new bond beam lintel with the bottom of the lintel at 7'-4" AFF.
- [3] Sheet a1.1 Level 1 – Demolition [plan]
3 areas are indicated as locations for the placement of debris disposal equipment and devices. Windows may be removed in two of these areas. Caution fencing will be required to segregate two of the areas from the public.
- [4] Sheet a1.3 Wall Section
Modify the design of the new wall as indicated.


C. R. FRANCIS / ARCHITECTURE p.a.




Charles R. Francis AIA




Located at
329 middle street

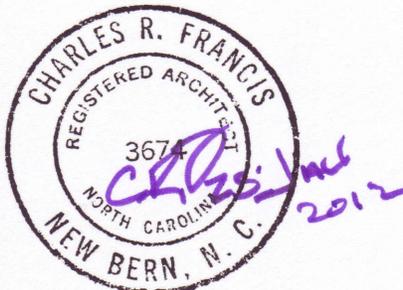

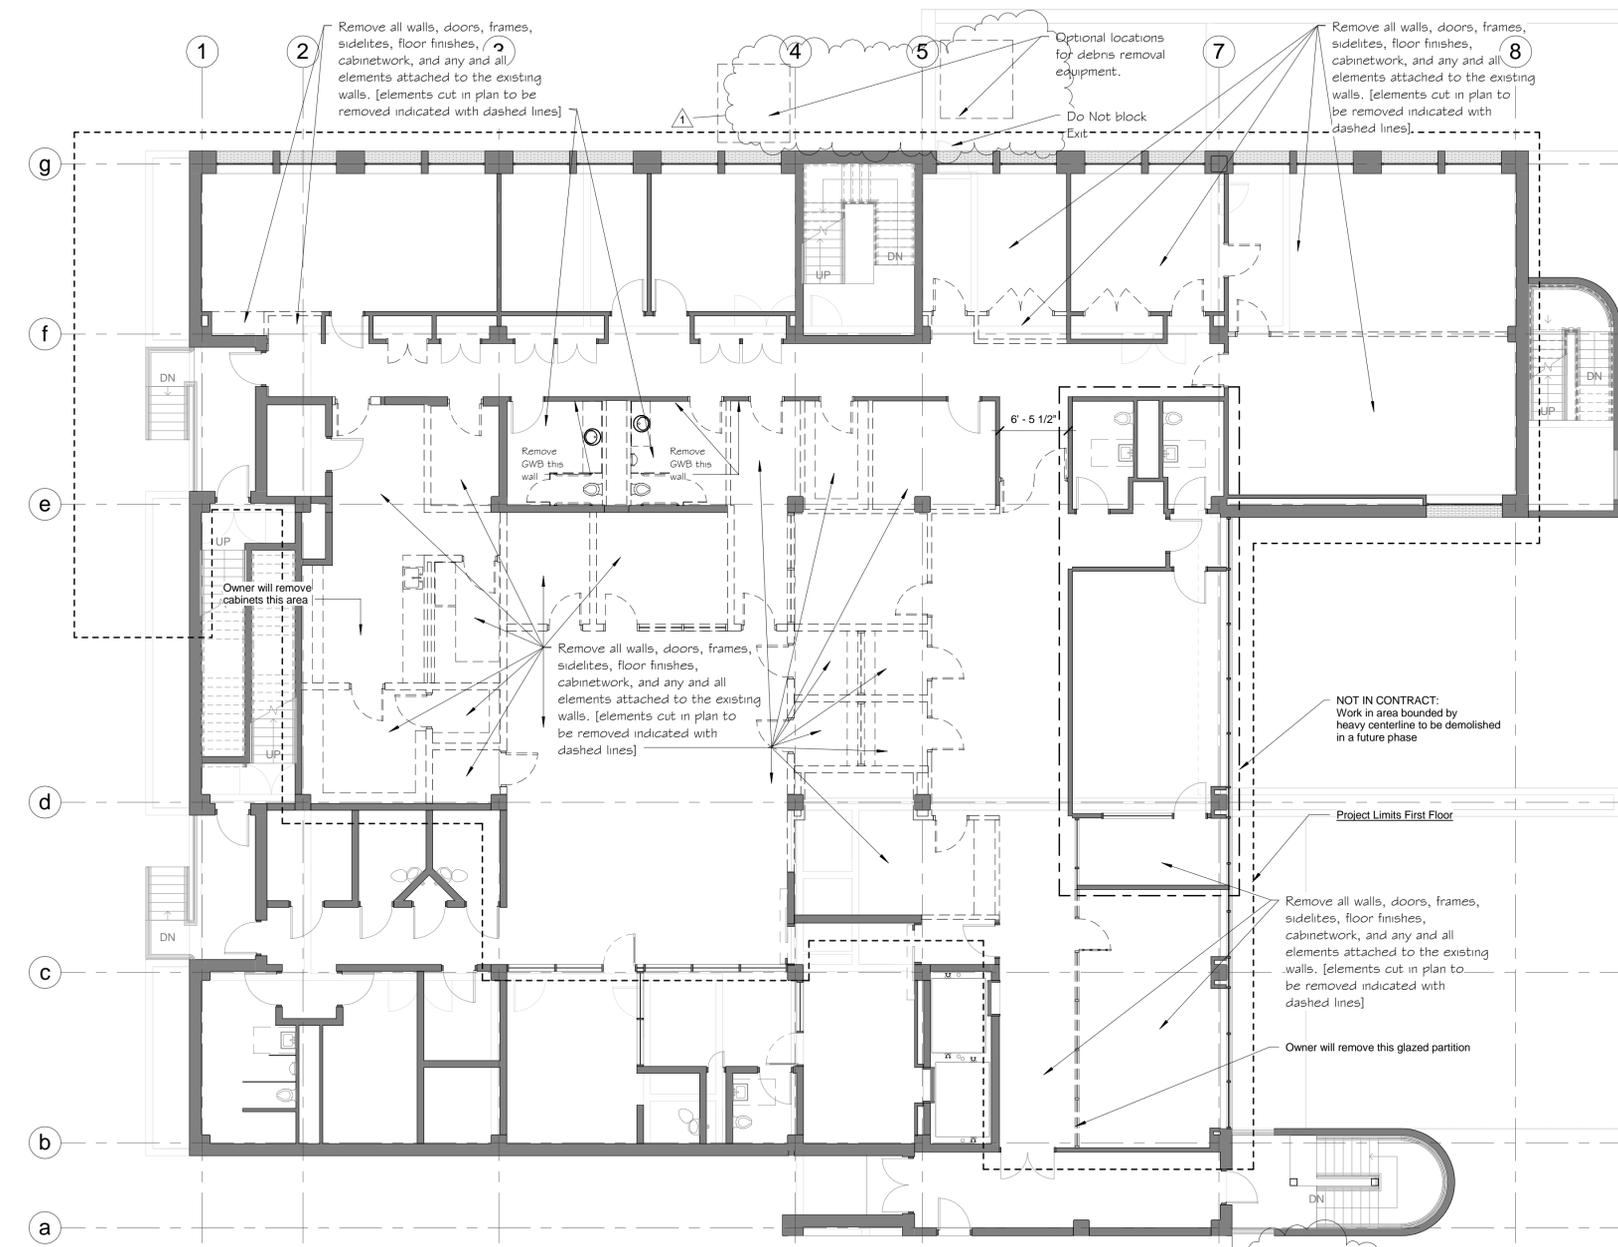


1 Level 1 - Demolition
1/8" = 1'-0"

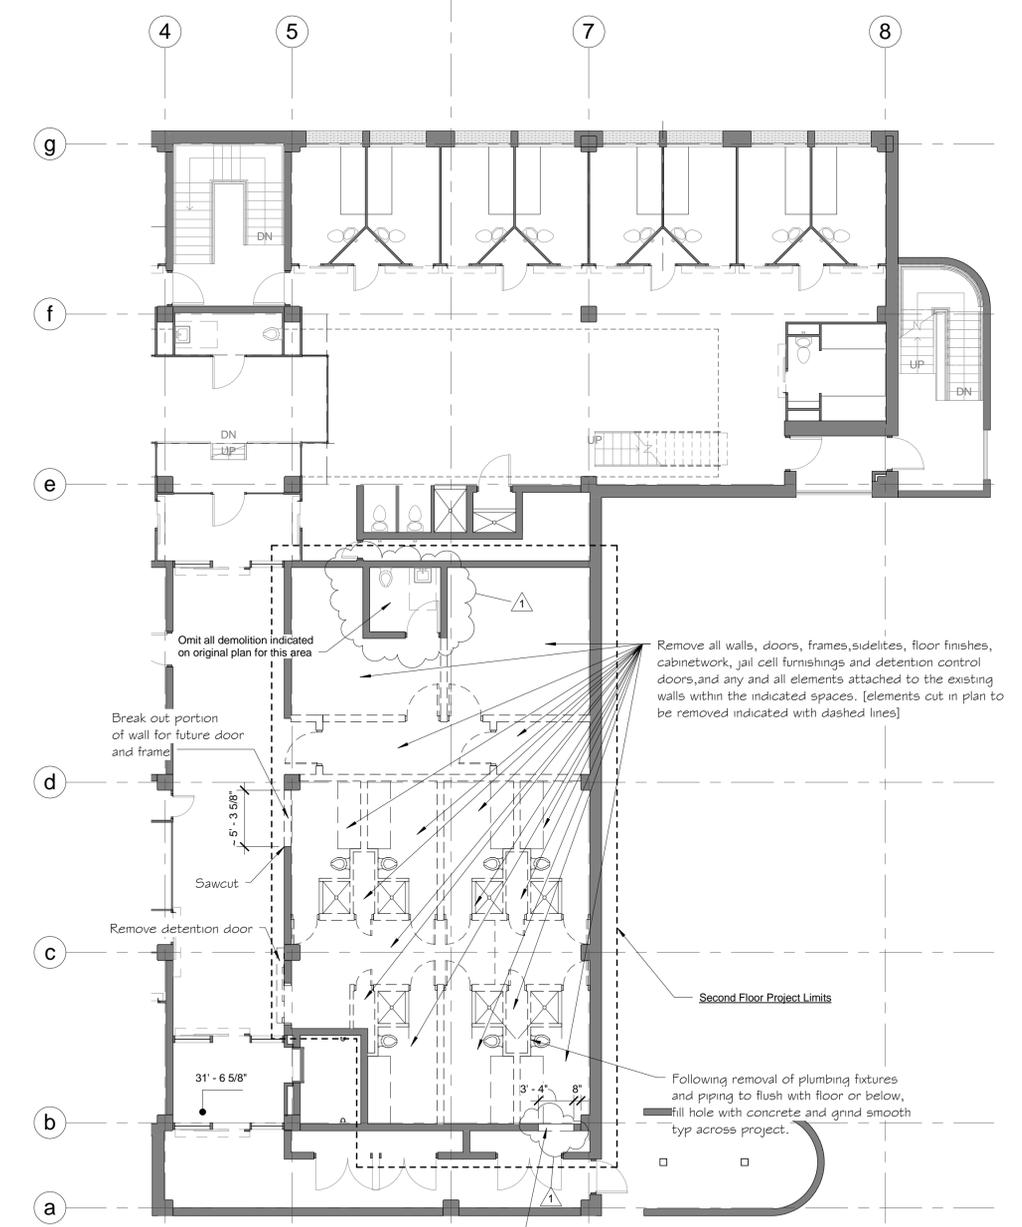


2 Level 2 - Demolition
1/8" = 1'-0"

Demolition Notes:

1. Plumbing: Remove all fixtures located within the project limits and not excluded by scheduling note. Cap waste lines and remove and cap water lines to above ceiling for future extension to new fixtures.
2. Electrical: Remove all light fixtures within project limits and not excluded by scheduling note leaving only those as desired for temporary construction lighting. Remove wiring and conduits from fixtures removed back to nearest junction box. In a like manner, where walls are indicated as being removed, remove electrical, data, and telecommunications conductors and conduits back to junction boxes located in ceiling or to the panel which ever is nearest. Where a full circuit is abandoned in removing lighting fixtures or receptacles, remove conductors and conduits back to panel and label the circuit "Spare" so that it may be reused for new circuiting.
3. Fire Alarm System: When walls or ceilings are indicated as being removed and fire alarm sensor and/or device is located thereon or in interstitial space, cap and or bag the device so as to remove the potential of false calls during demolition operations and allow the device to hang in the space. Remove the cap or bag at the end of the day to allow system to fully operate and recap or bag when operations resume. If system is to be fully deactivated at any time, review with local fire marshal prior to deactivation for instructions and requirements of fire marshal office for life safety.

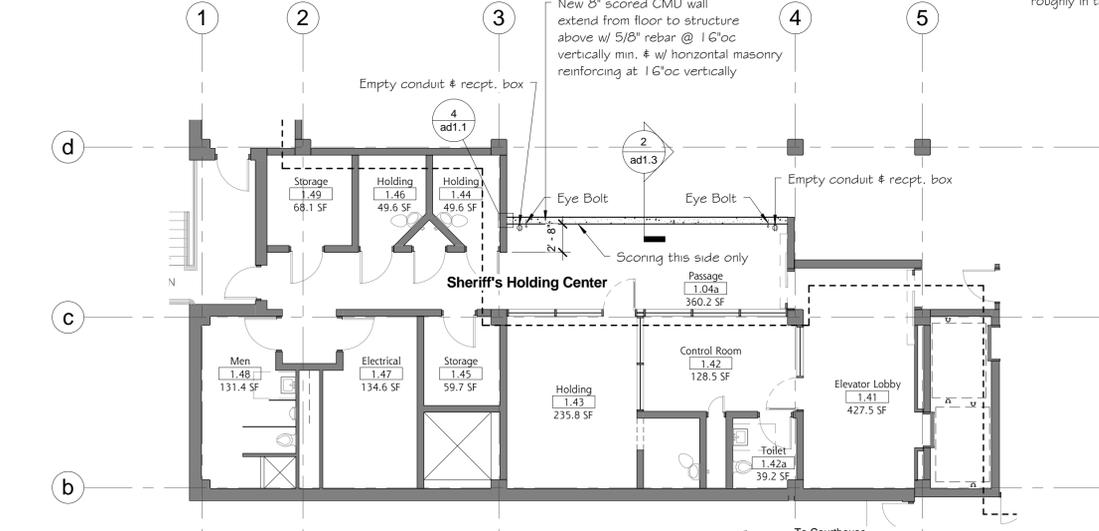

3 Level 1 - Phase 1
1/8" = 1'-0"

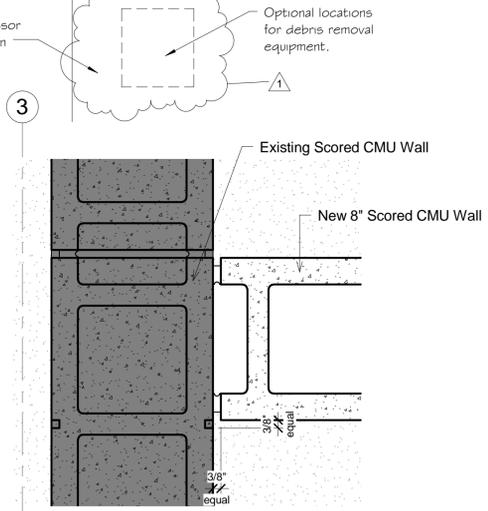

4 Detail - CMU Intersecting Wall - Phase 1
3" = 1'-0"


No.	Description	Date
1	Changes to second level demolition & Wall Section	25 Jan 2012

Adaptive Reuse: Craven County Jail to Emergency Operations Center


Craven County Craven Street New Bern, NC



1/25/2012 1:43:08 PM E:\A-Projects\Craven County Jail\Option 1.rvt

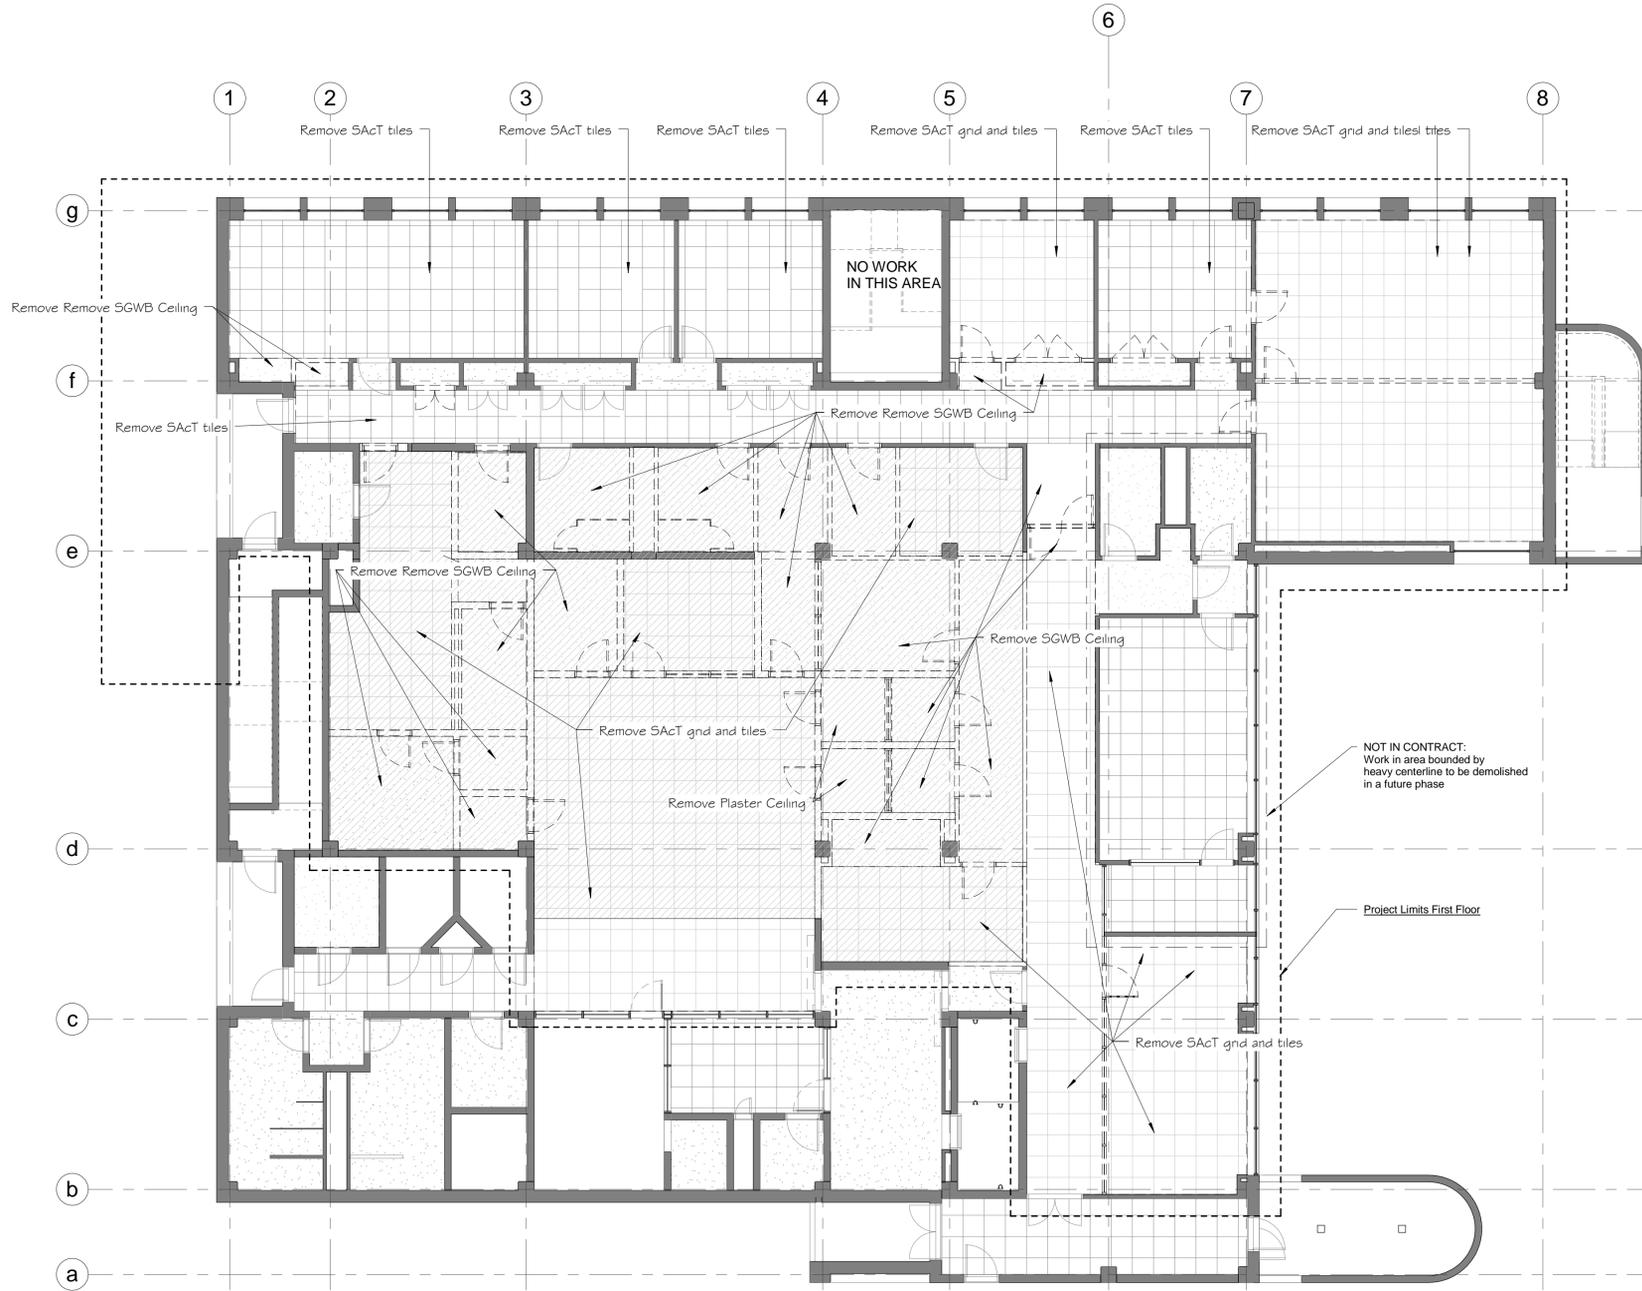

1 Level 1 - Demolition
1/8" = 1'-0"

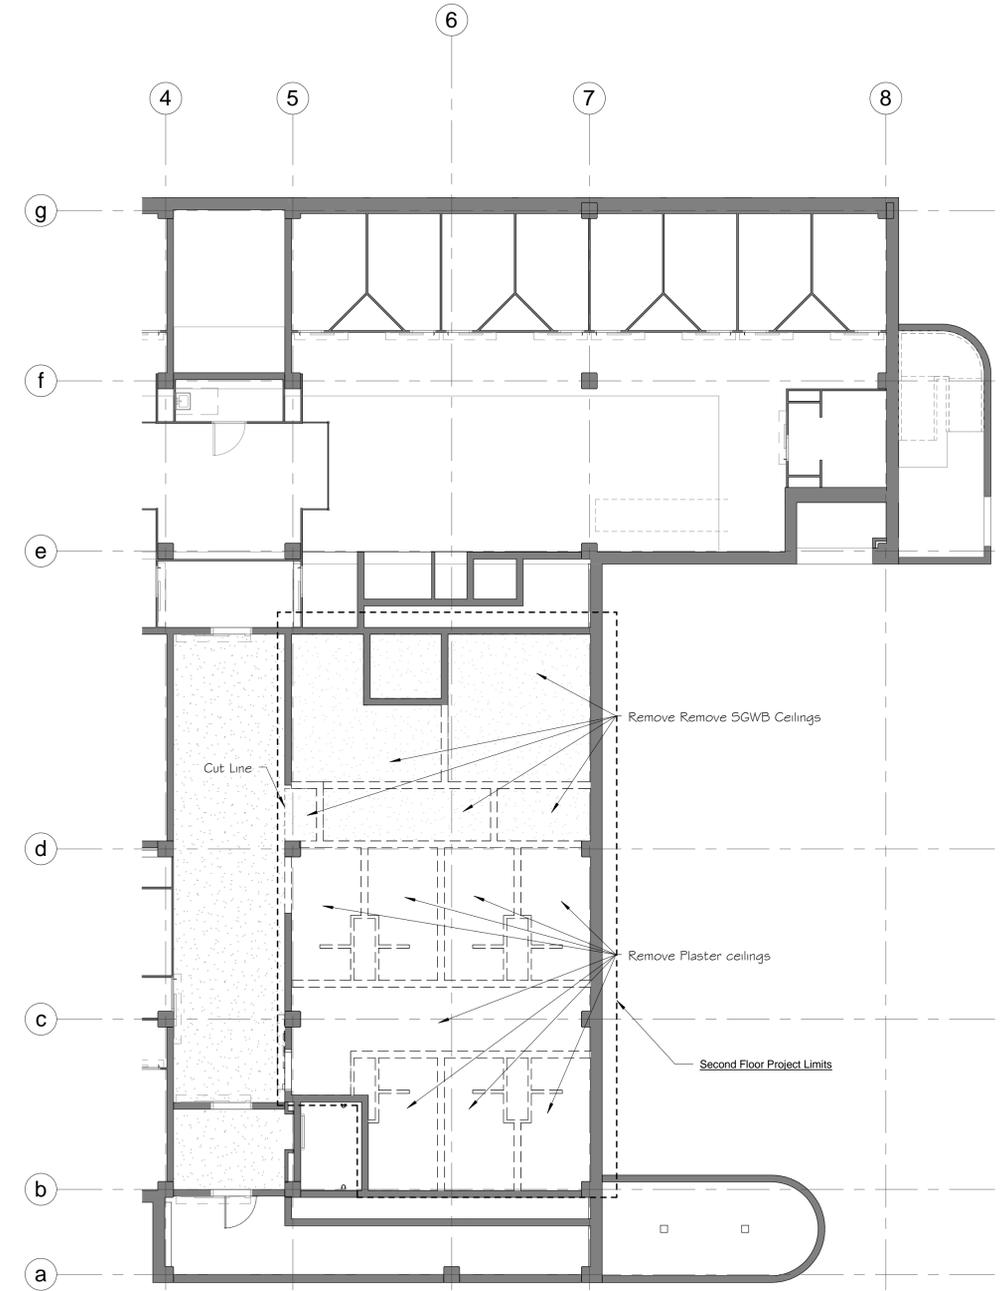

2 Level 2 - Demolition
1/8" = 1'-0"

Demolition Notes - reflected clgs/HVAC:

1. Remove any and all furred areas above cabinetwork adjacent cabinets and/or walls to be removed.
2. Remove any and all bulkheads separating ceilings that are to be removed.
3. Above ceilings denoted thusly, remove HVAC diffusers and ductwork back to VAV boxes serving the indicated areas. Cap openings on VAV boxes to prevent the entrance of dirt and dust. Note that other ceiling designations appear in denoted in the overlay hatch pattern and that the overlay hatch pattern only designates the area served, not necessarily the location of ductwork to be removed. A copy of the original ductwork drawing for the work involved is shown on sheet ad1.5. Mainline ductwork on the air handler side of the VAV boxes are to remain in place.
4. In other areas within the project limits, remove in conjunction with the electrical demolition subcontractor fluorescent fixture air troffers and associated flex ducts back to rigid ductwork. Cap openings in rigid ductwork to prevent the entrance of dirt and dust.
5. Unless noted otherwise, where supply and return diffusers and grills are ceiling and/or wall mounted, remove diffuser or grill and cap openings as required for other conditions.

Adaptive Reuse: Craven County Jail to Emergency Operations Center



Craven County Craven Street New Bern, NC



C. R. FRANCIS / ARCHITECTURE

located at 329 middle street p. o. box 1387 new bern, north carolina 28563 tel. (252) 637-1112 fax (252) 637-7698 p.a.
These Drawings (the graphic representation of the design) and the Architectural Design(s) indicated herein created by C. R. Francis, Architecture, p.a. remain the property of the Architect. They are protected under the 1990 Architectural Works Copyright Protection Act. Reproduction or reuse of these documents or designs is prohibited without written consent of the Architect. COPYRIGHT

sheet ad1.2
Date: 2012 Drawn by: crf Sequential No. 01

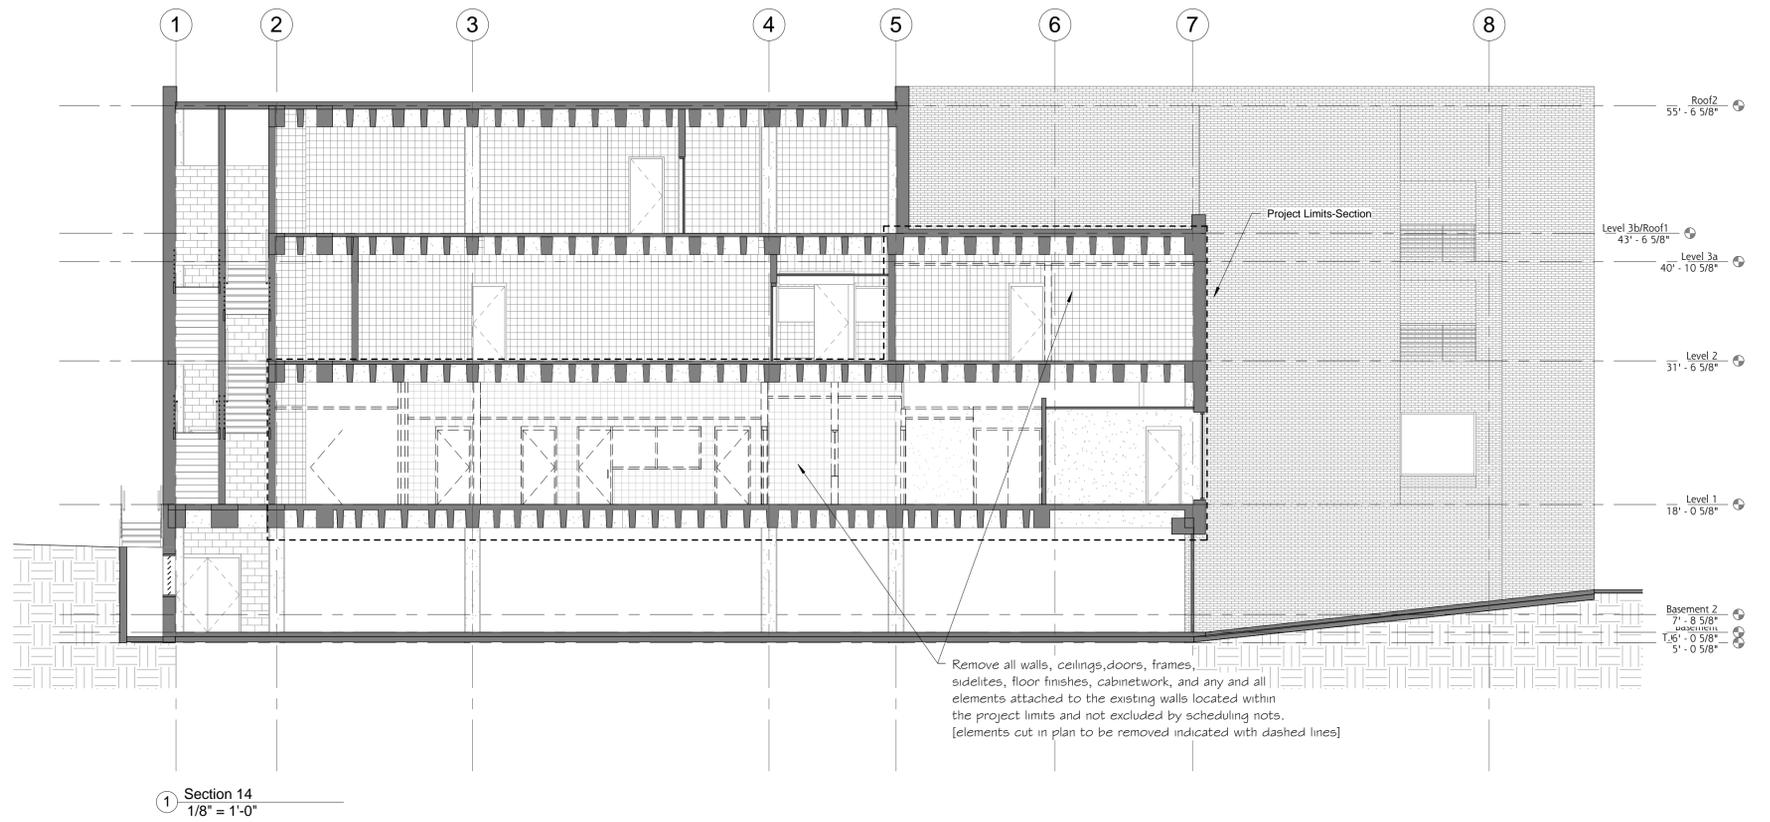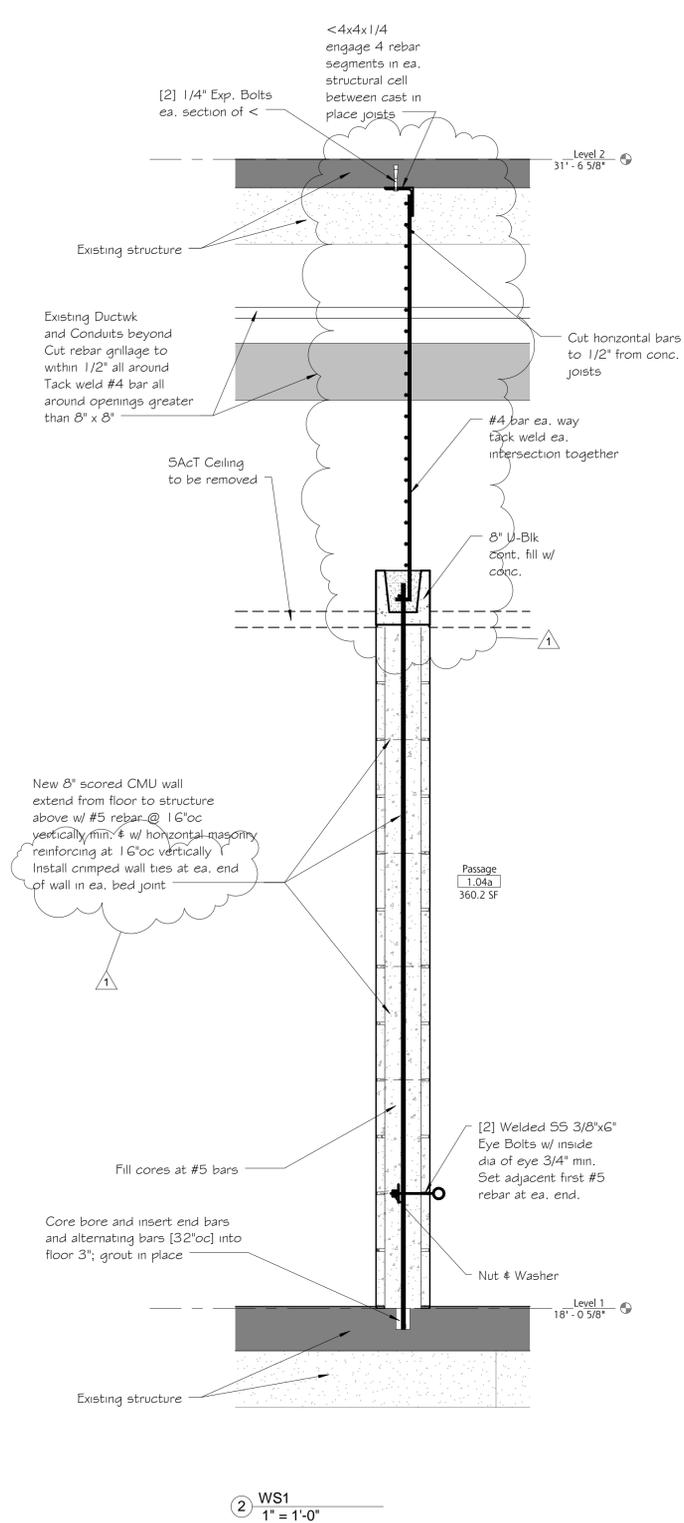

1/25/2012 1:43:11 PM E:\A-Projects\Craven County Jail\Option 1.rvt

Adaptive Reuse: Craven County Jail to Emergency Operations Center

Craven County Craven Street New Bern, NC

No.	Description	Date
1	Changes to second level demolition & Wall Section	25 Jan 2012



C. R. FRANCIS / ARCHITECTURE
 located at 325 middle street p. o. box 1387 new bern, north carolina 28563 tel. (252) 637-1112 fax (252) 637-7698 p.a.
These Drawings (the graphic representation of the design) and the Architectural Design(s) indicated herein created by C. R. Francis, Architecture, p.a. remain the property of the Architect. They are protected under the 1990 Architectural Works Copyright Protection Act. Reproduction or reuse of these documents or designs is prohibited without written consent of the Architect. COPYRIGHT

sheet ad1.3
 Date: 2012 Drawn by: Author Sequential No. 01